

REVISIONS:	BY:
ERROR ELEVATOR:	JAC

DESIGN HOUSE ARCHITECTURAL SERVICES, LLC

James A. Childress
 An Illinois Licensed Professional Design Firm
 4562 Cantano St., Unit F
 Yorkville, Illinois 60580
 phone 630-335-2462
 mobile 630-335-3094
 fax 630-335-3094
 PTF License No. 18400933

FLOOR PLAN

ADDITION TO GENERAL LABORATORY PRODUCTS, INC.
 202 E. WOLF ROAD
 YORKVILLE, ILLINOIS

DATE: 11/27/2016
 SCALE: AS NOTED
 DRAWN BY: JAC
 PROJECT NO.: 251101
 SHEET: AI
 OF: 9 SHEETS

Copyright © 2016 Design House Architectural Services, LLC / Middle Builders - Reproduction of these plans and/or reports were prepared under my direct supervision and to the best of my knowledge conform to the building codes / ordinances of North Aurora, Illinois

BUILDING CODES
 ALL WORK SHALL CONFORM TO THE FOLLOWING ADOPTED CODES OF THE CITY OF YORKVILLE, ILLINOIS
 2018 INTERNATIONAL BUILDING CODE (IBC)
 2018 INTERNATIONAL ELECTRICAL CODE
 2018 ILLINOIS PLUMBING CODE
 2018 ILLINOIS MECHANICAL CODE
 2018 INTERNATIONAL ENERGY CONSERVATION CODE

DRAWING INDEX
 A1 EXTERIOR ELEVATIONS
 A2 FLOOR PLAN / DETAILS


DESIGN HOUSE ARCHITECTURAL SERVICES
 THIS IS TO CERTIFY THAT THESE PLANS AND/OR REPORTS WERE PREPARED UNDER MY DIRECT SUPERVISION AND TO THE BEST OF MY KNOWLEDGE CONFORM TO THE BUILDING CODES / ORDINANCES OF NORTH AURORA, ILLINOIS

Alberto Aguirre
 ALBERTO AGUIRRE, CONSULTING ARCHITECT
 EXPIRES 11/30/2016

STATE OF ILLINOIS
 ARCHITECT
 ALBERTO AGUIRRE
 001-000499
 SITE OF PROFESSIONAL SERVICE



EAST ELEVATION
 SCALE: 1/4" = 1'-0"

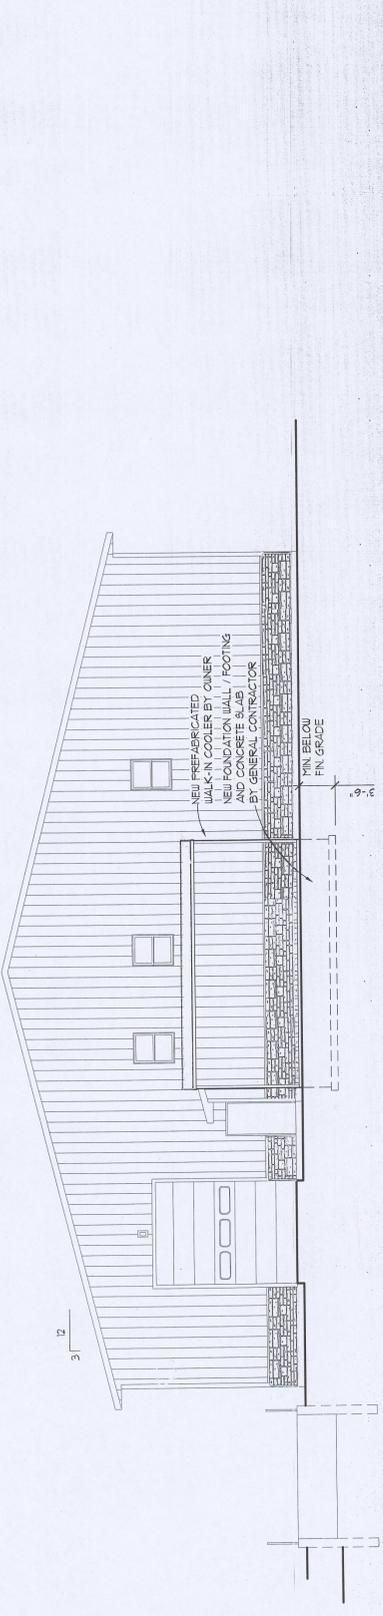

NORTH ELEVATION
 SCALE: 1/4" = 1'-0"



WEST ELEVATION
 SCALE: 1/4" = 1'-0"

